


SCALE: 1/4" = 1'-0"

Precision dial
P.O. Box 2384 Pearland, Texas 77588
281-509-9906 pdg_texas®yahoo.com
Revisions Date Description
A NEW SPEC
LOT 78, BLOCK 1 MAGNOLIA CROSSING 715 CREEK CROSSING MAGNOLIA, TEXAS 77355
715CC Sheet Date: 10/29/2022 Sheet Title: EXT. ELEVATIONS FRONT & LEFT Sheet No.:
A5-O Drawn By Project Manager Builder GRS JW VANGUARD BLDRS. © 2021 PRECISION DESIGN GROUP. All rights reserved. No parts of this document may be reproduced or used in any form without prior authorization from PRECISION DESIGN GROUP.

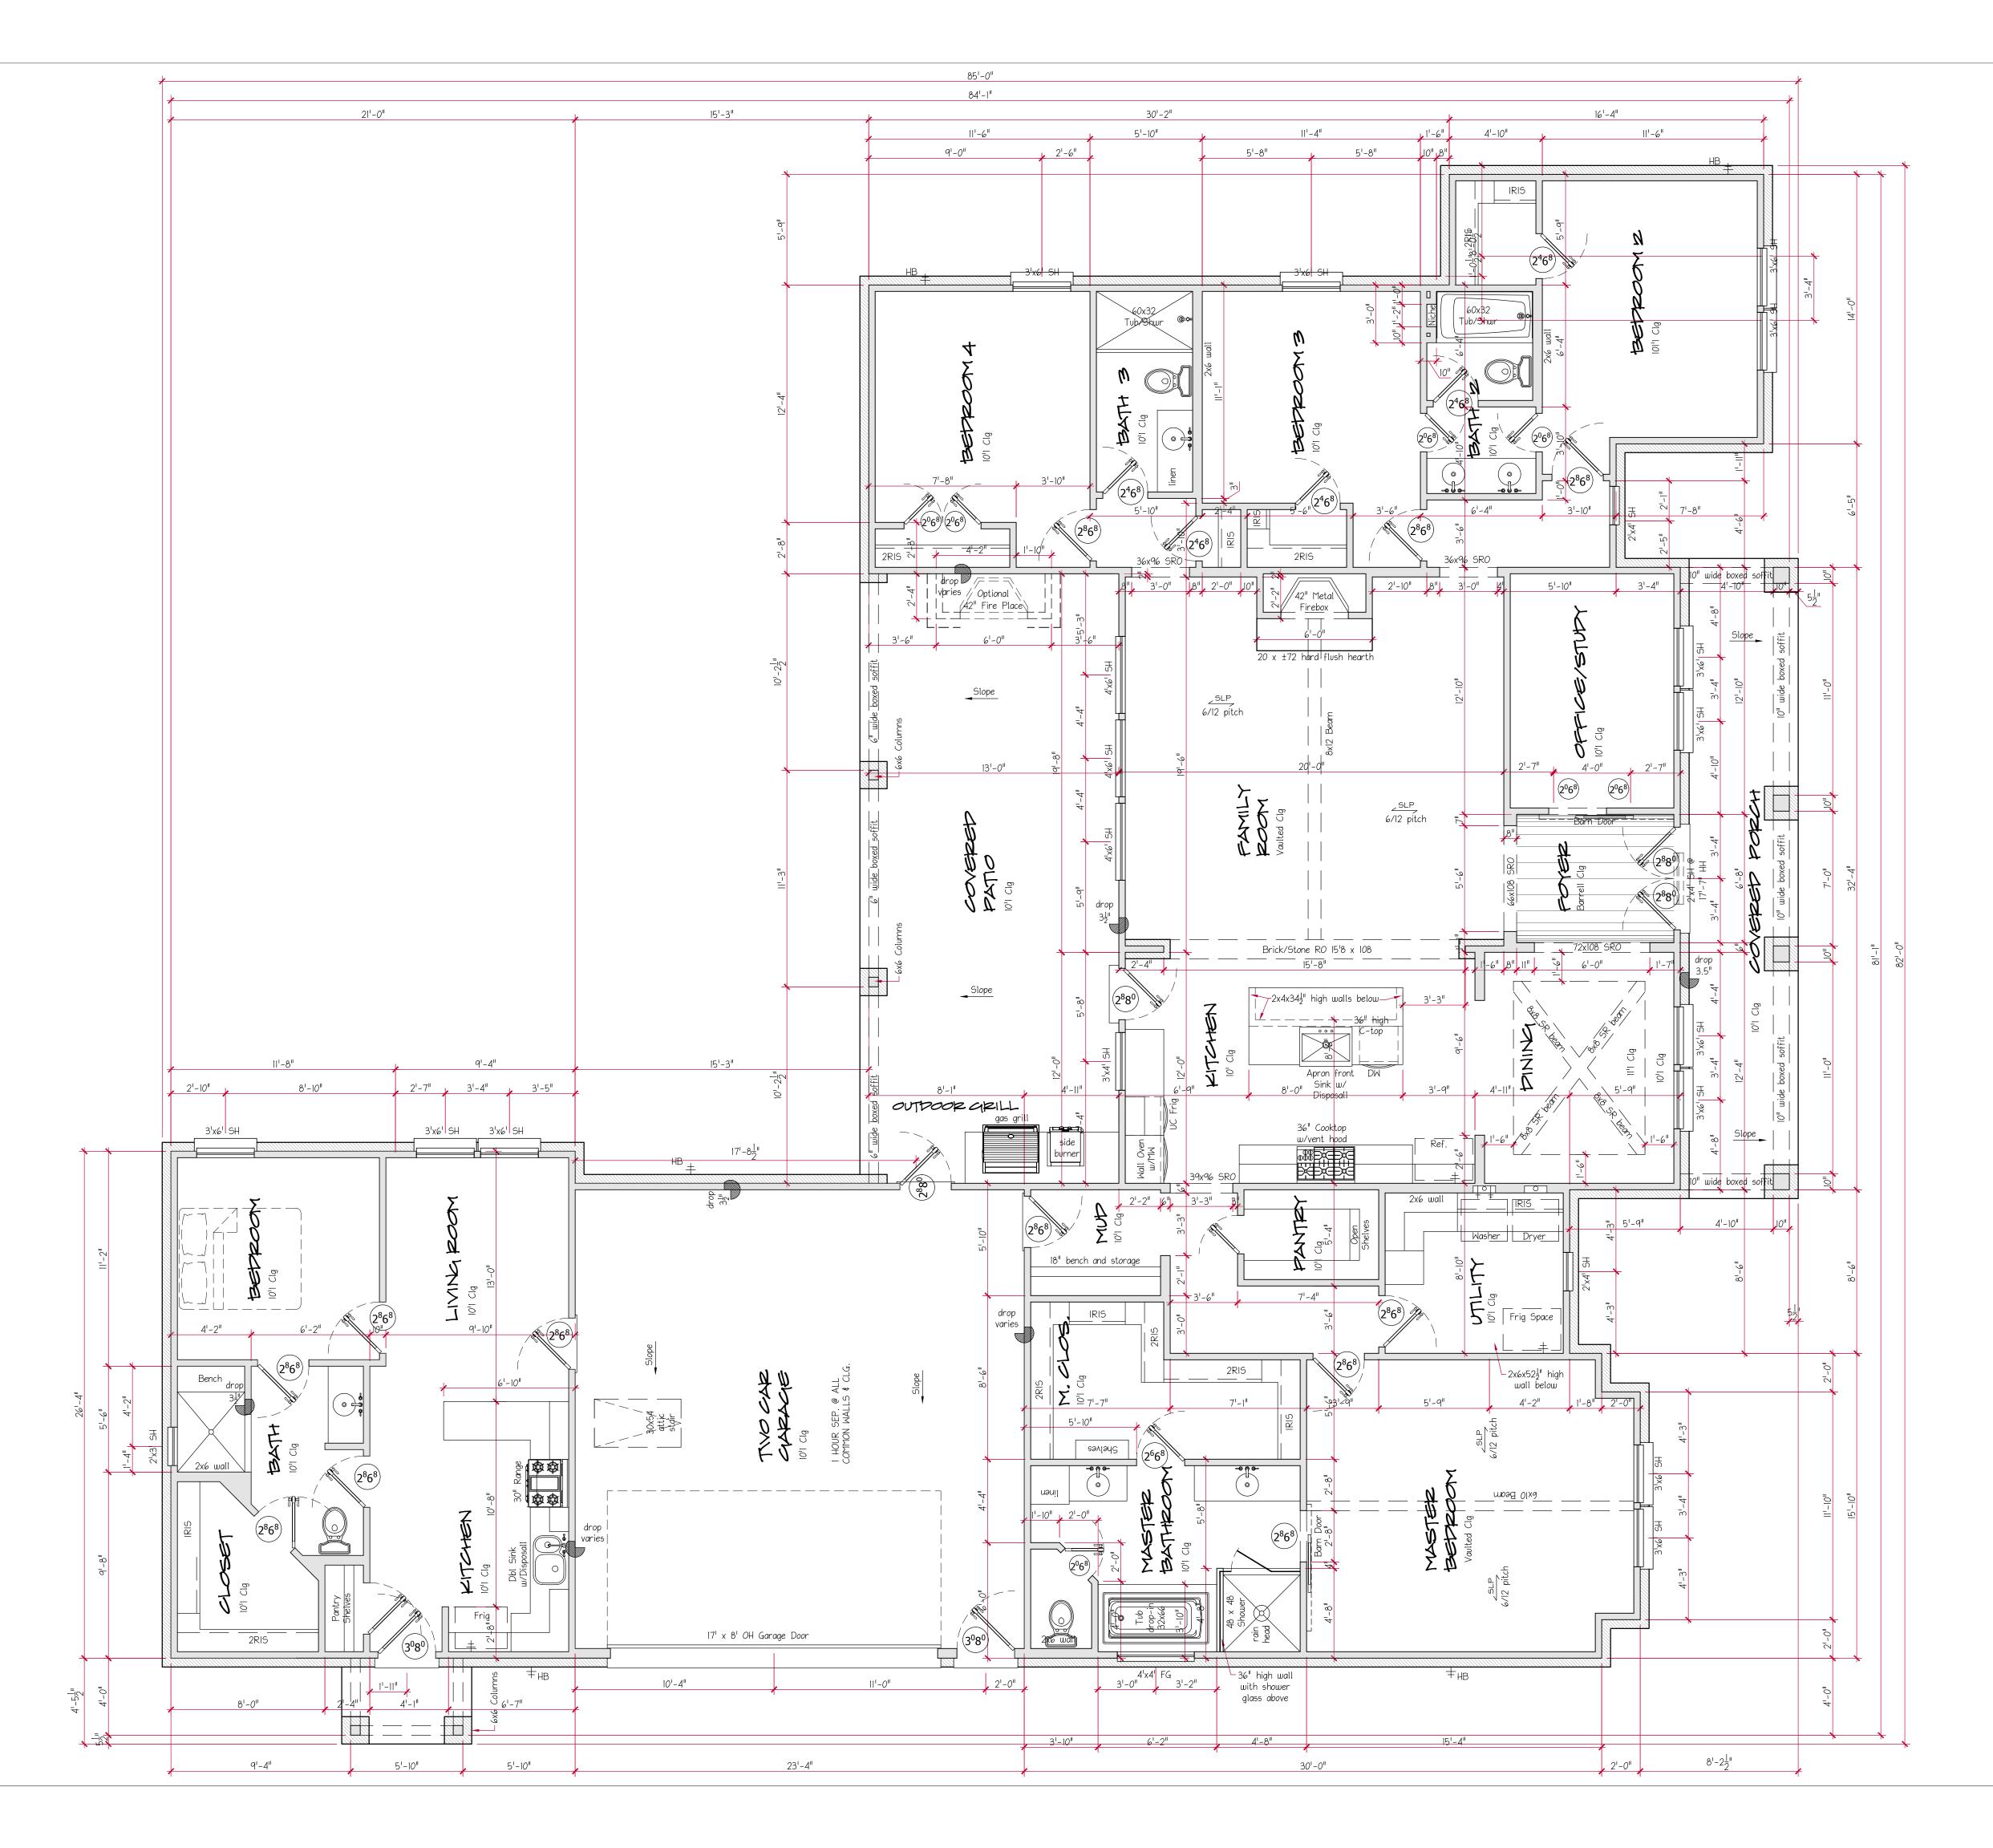


FLOOP PLAN	SCALE: $1/4^{"} = 1^{-}0^{"}$	
)


(<u>}</u>		.0									
ł	F 2	'ea 281: g_t	rle 7 -5	75	d, 58 9-	Т 8 9	e> 9(s	n	
Revi s Date			ript	ior)						
	2 2 2 2 2 2	Z Z		2,507 ^d	594₫	1 23 ª	425ª	3,093 ^d	1,234 ⁵	4,326₫	4,326 ^d
				<i>N</i>				<i>III</i>		4	4
REAS		Hodod		ABEA		Hodo			AREA		
BUILDING AREAS	2 AVAPTERS	quarters front popul		MAIN HOUSE LIVING AREA	SOAR CARACIE	FRONT GOVERED POPERH	ohad dealeroo	TOTAL LIMNER AREA	TOTAL NON-LIMINCI AREA	TOTAL SLAD	TOTAL FRAME
L HT	a		 А	N			-	F	F	ŕ	F
		-	S	Pl							
		MAC		LIA	CR	IOS	SIN				
			CRE AGN		Α, Ί						
			4GIV				.A3)			


SYMBOLS ARE DRAWN I MAY OR MAY NOT ALL HIS SET OF DRAWINGS. 2'x4' flourescent light celling fixture 1'x4' fluorescent light celling fixture	Vanity wall mount fixture Vanity wall mount fixture above cabinet up-lighting IRON BOARD Ironing board (moy or may not be built in) Ironing board (moy be switched current (moy be	ist.)	Ceiling fan fixture (may or may not hove a light kit) Clg Fan light kit) Gas valve or gas outlet
TYPICAL SYI THE FOLLOWING TYPICAL SYMBOLS IN PLAN, TO SCALE, AND MAY OD IN PLAN, TO SCALE, AND MAY OD OR ANY BE SHOWN IN THIS SET Single pole switch In the way switch E Four way switch P Boo octivated switch	 Duplex receptacle outlet 220 volt outlet Mater resistant outlet Ground fault interrupter outlet Mall mount light fixture Mall or ceiling mount floodlight fixture Television outlet Data outlet Intercom outlet 	C Ceiling mount light fixture Imaging ceiling light fixture Imaging ceiling light fixture (mulated) Imaging Recessed ceiling light fixture (non insulated) Imaging Recessed ceiling light fixture (water resist.) Imaging Recessed directional ceiling light fixture	 Pin Down light Thermostat control Thermostat control Combo C02/Smoke detector Heat sensor Speaker location Floor outlet Mall Mount fixture Under Counter Lighting Rope Lighting



 

Precisi
esign d'
P.O. Box 2384 Pearland, Texas 77588
281-509-9906 pdg_texas@yahoo.com Revisions
Date Description
A NEW SPEC
LOT 78, BLOCK 1 MAGNOLIA CROSSING 715 CREEK CROSSING MAGNOLIA, TEXAS 77355
715CC
Sheet Date: 10/29/2022 Sheet Title:
POWER &LIGHTING PLAN Sheet No.:
A4-0
Drawn By Project Manager Builder GRS JW VANGUARD BLDRS. © 2021 PRECISION DESIGN GROUP. All rights reserved Na parts of this document may be reproduced
reserved. No parts of this document may be reproduced or used in any form without prior authorization from PRECISION DESIGN GROUP.

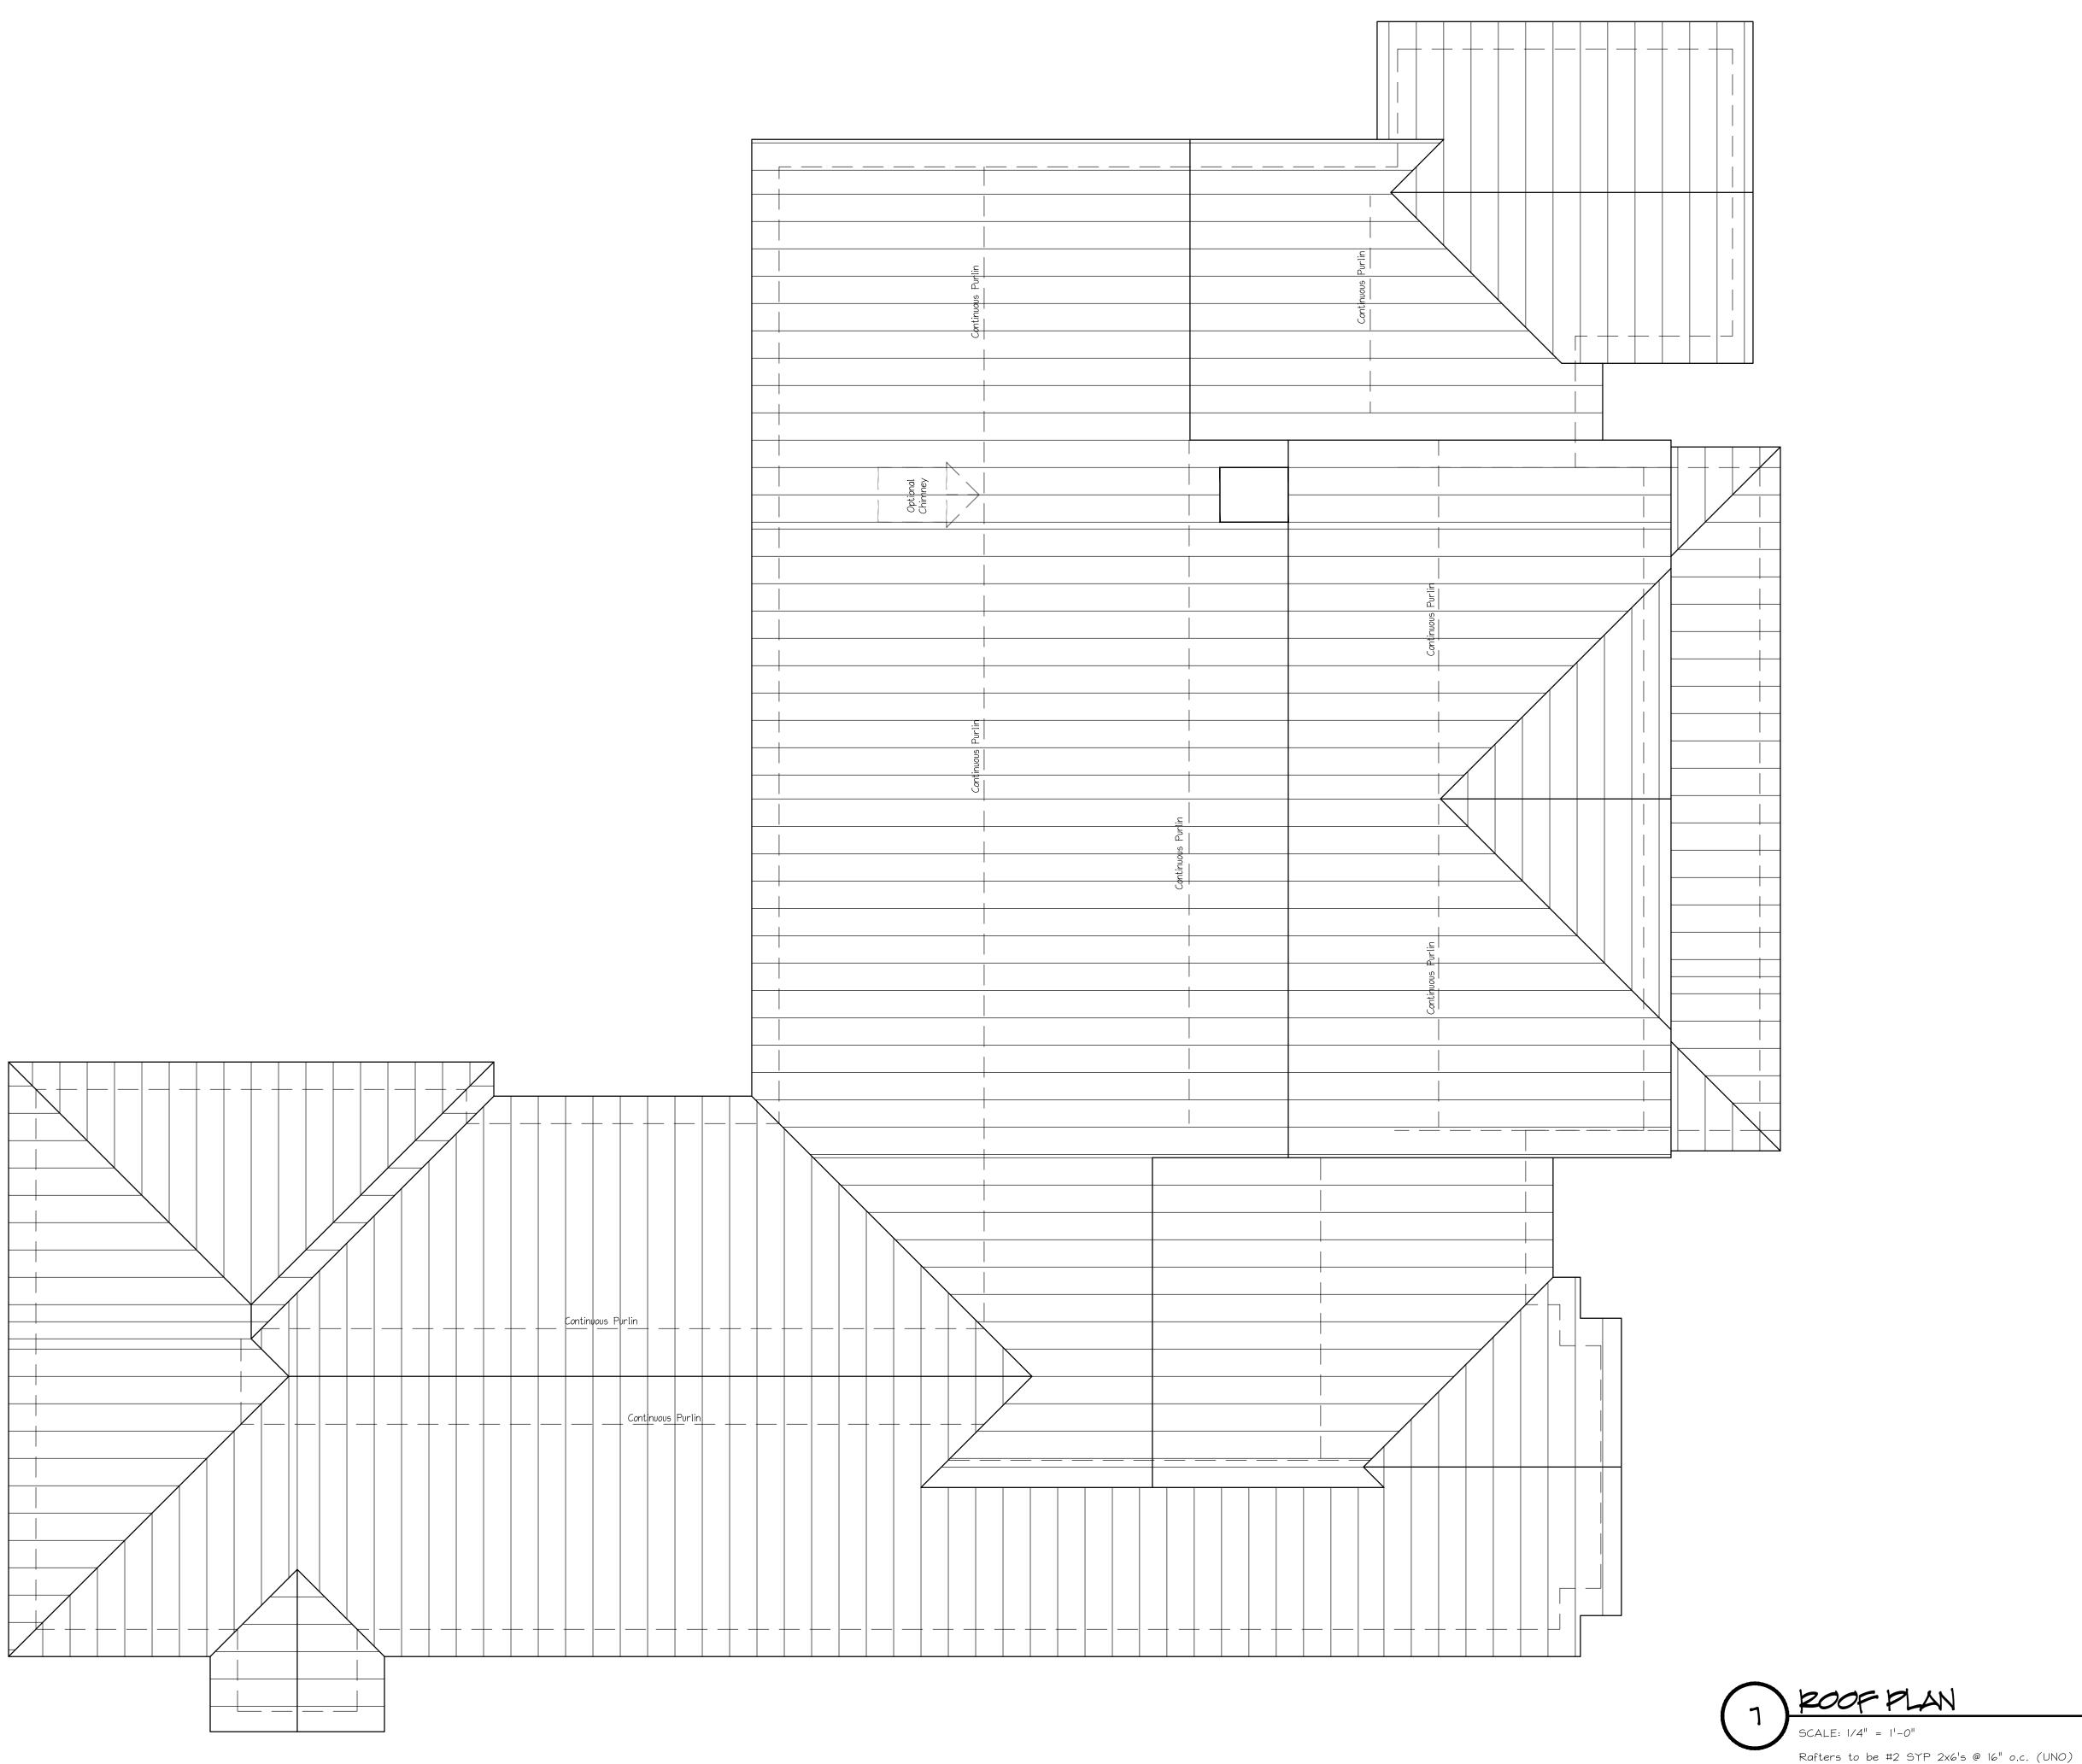

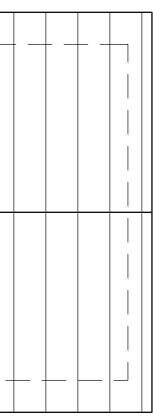

	F	28 [.]	arla 7 1-5	an 77 50	d, 58 9-	2: Te 8 99 aho	xa 000	.s 6	= ר
Revi Date			crip	tior	 ר				
									_
			S	P	E	_			
						0551 0551			












	,
Precision of the state	
Cesign G	
P.O. Box 2384 Pearland, Texas 77588	
281-509-9906 pdg_texas®yahoo.com	
Revisions Date Description	_
A NEW SPEC	
LOT 78, BLOCK 1 MAGNOLIA CROSSING 715 CREEK CROSSING MAGNOLIA, TEXAS 77355	
715CC Sheet Date: 10/29/2022 Sheet Title: INTERIOR FLEVATIONS L	
ELEVATIONS I Sheet No.: A6–O Drawn By Project Manager Builder	
© 2021 PRECISION DESIGN GROUP. All rights reserved. No parts of this document may be reproduced or used in any form without prior authorization from PRECISION DESIGN GROUP.)

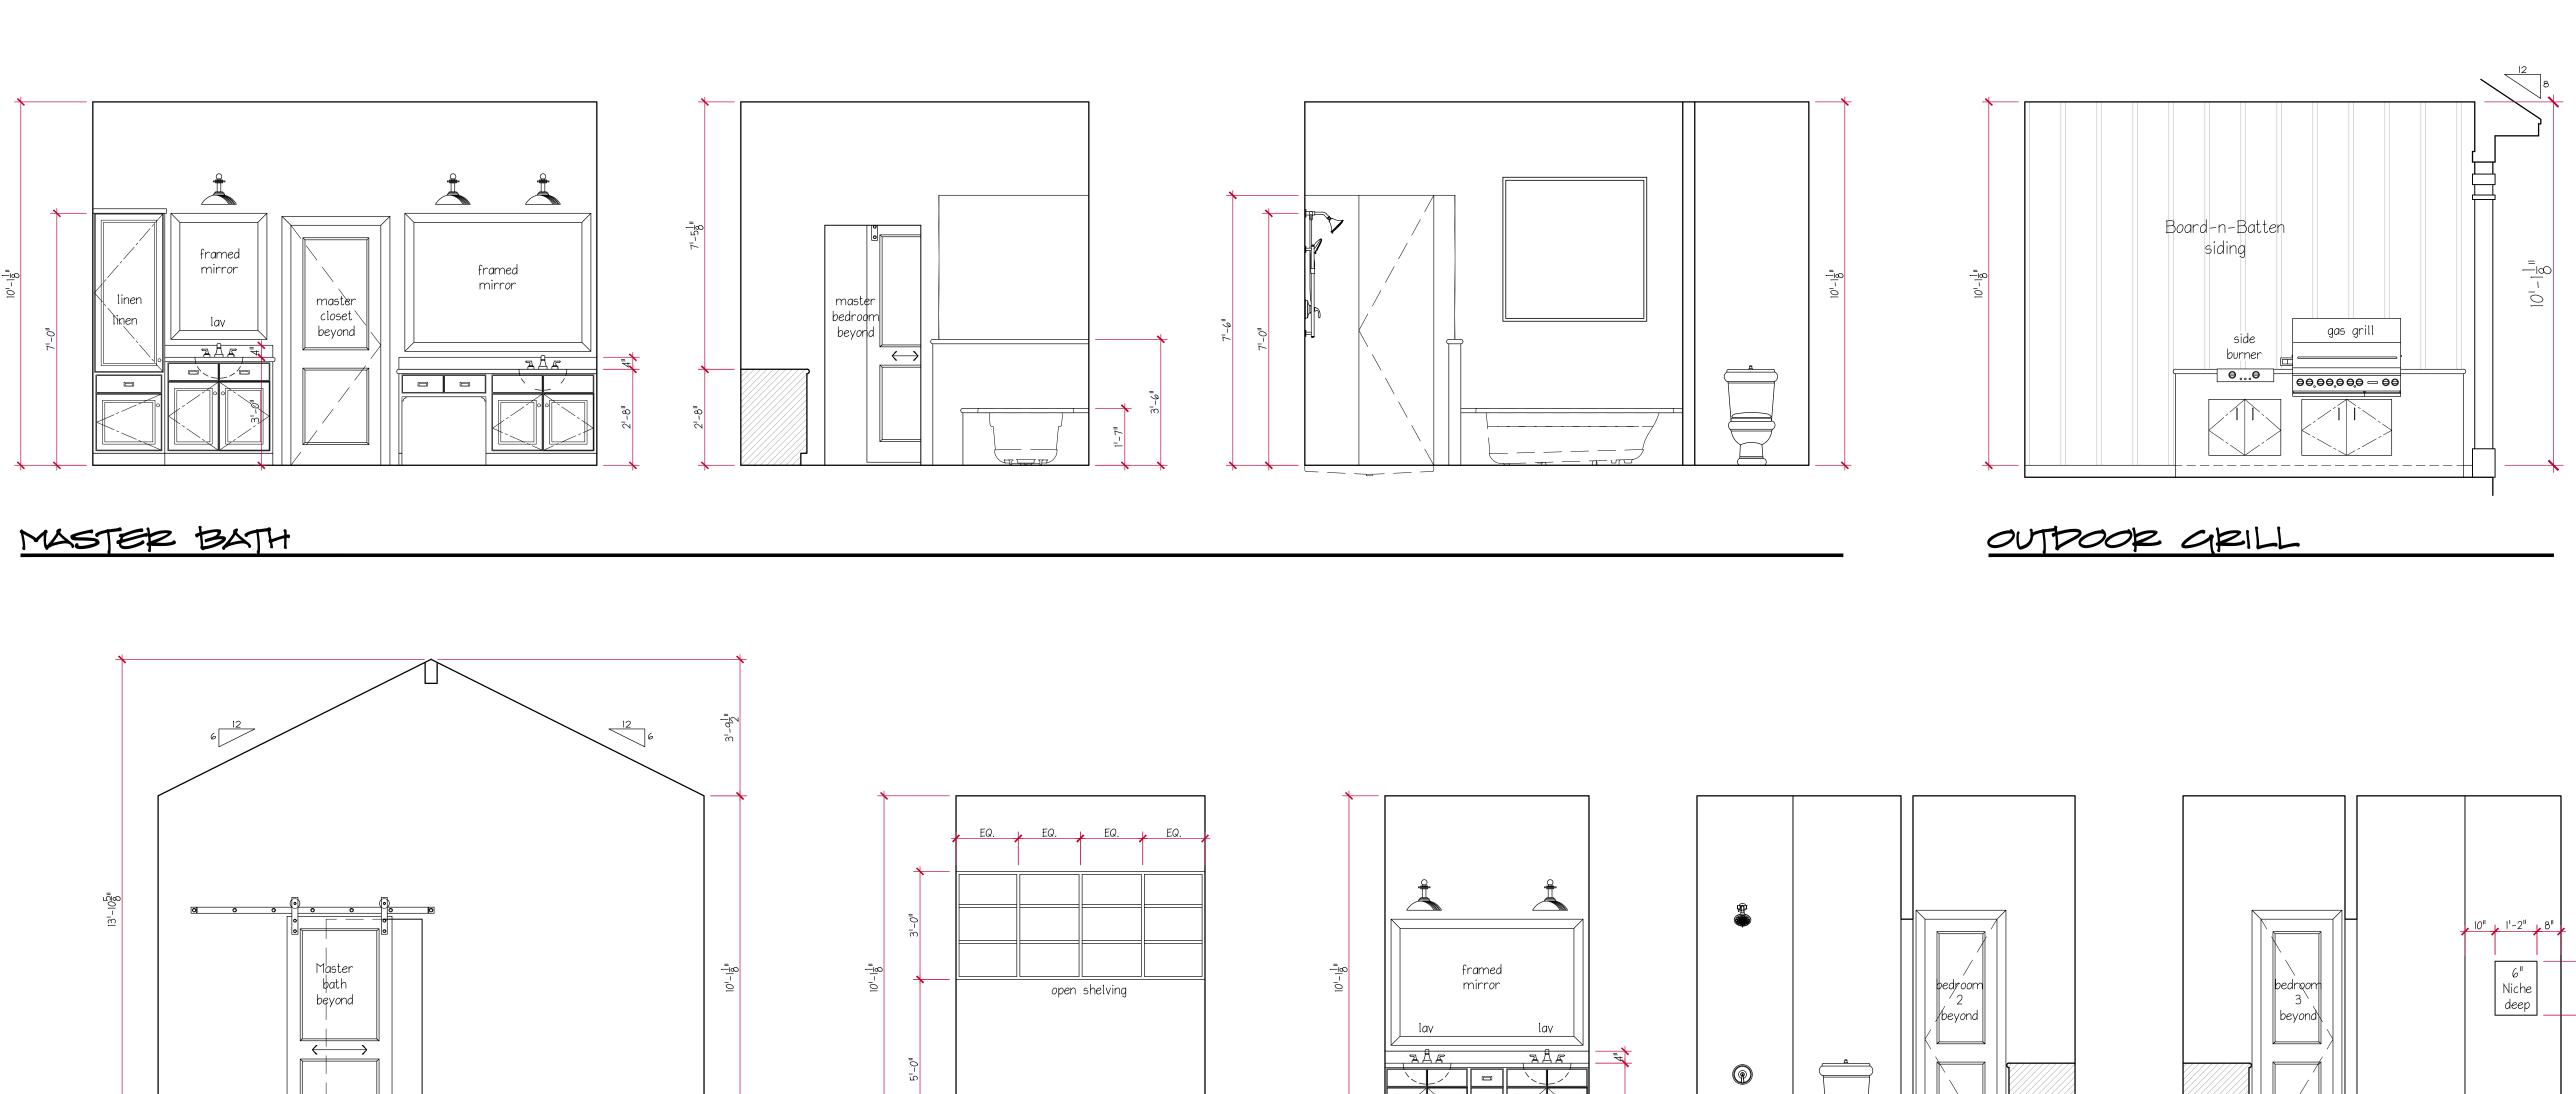

BATH 2



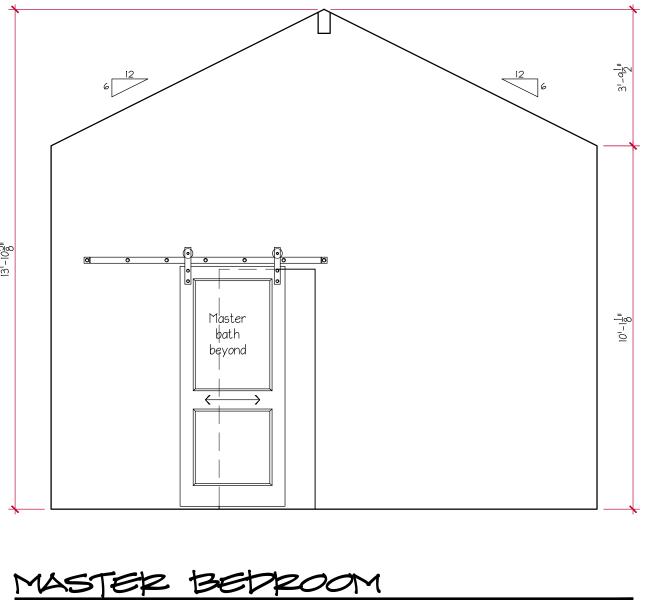

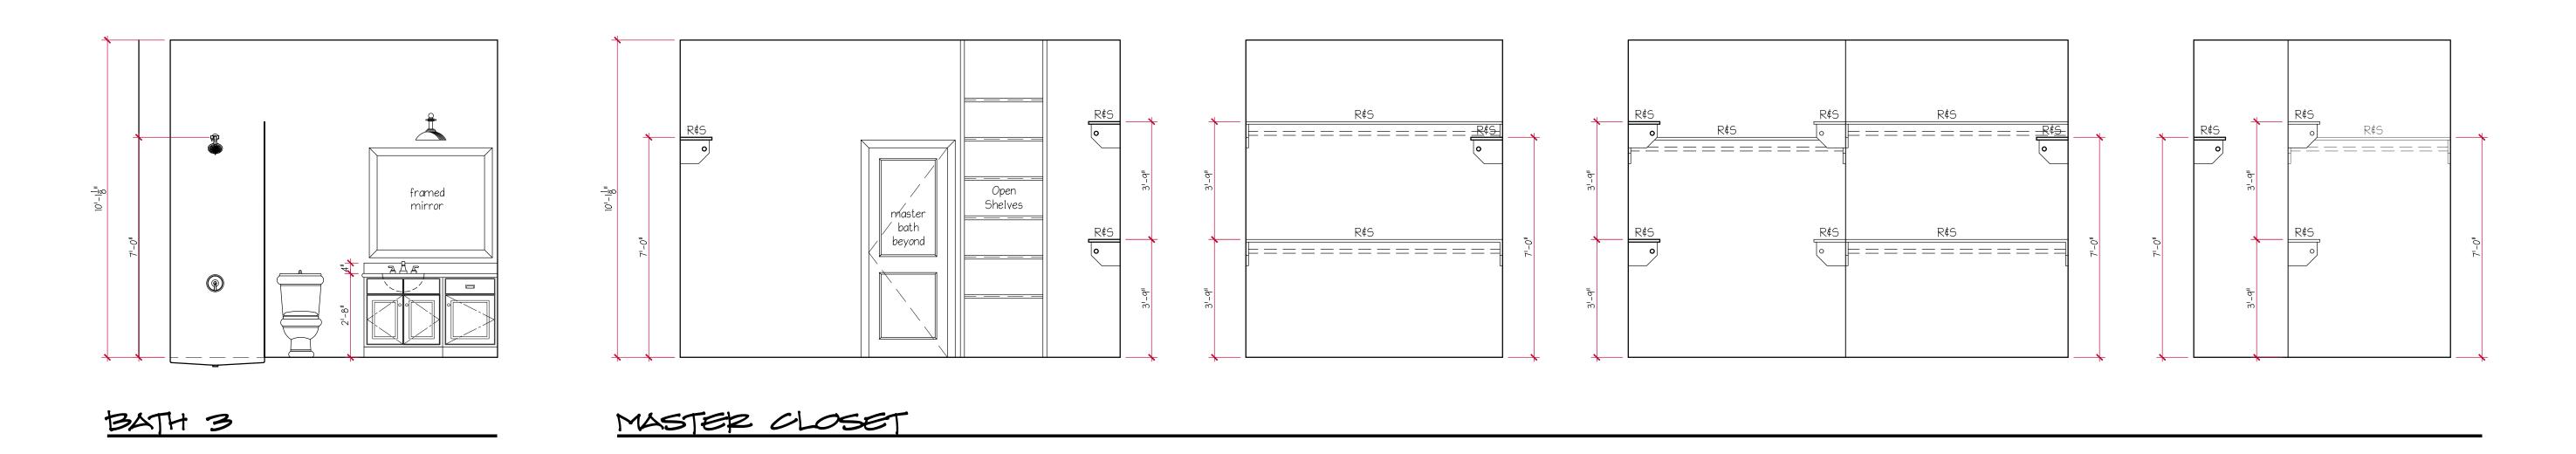



mud bench


MUD ENTRY

SCALE: 3/8" = 1'-0"

Ē		D. E		x 2			
		7	75	, Te 88 -99			
k	odg_	_tex	(88ª)	ahc	o.c	om	
Revi s Date		scrin	tion				
Sheet	71		78, BI DLIA C EEK C NOLIA 7735	_OCK ROSS TEXA 5	1 NNG		

 

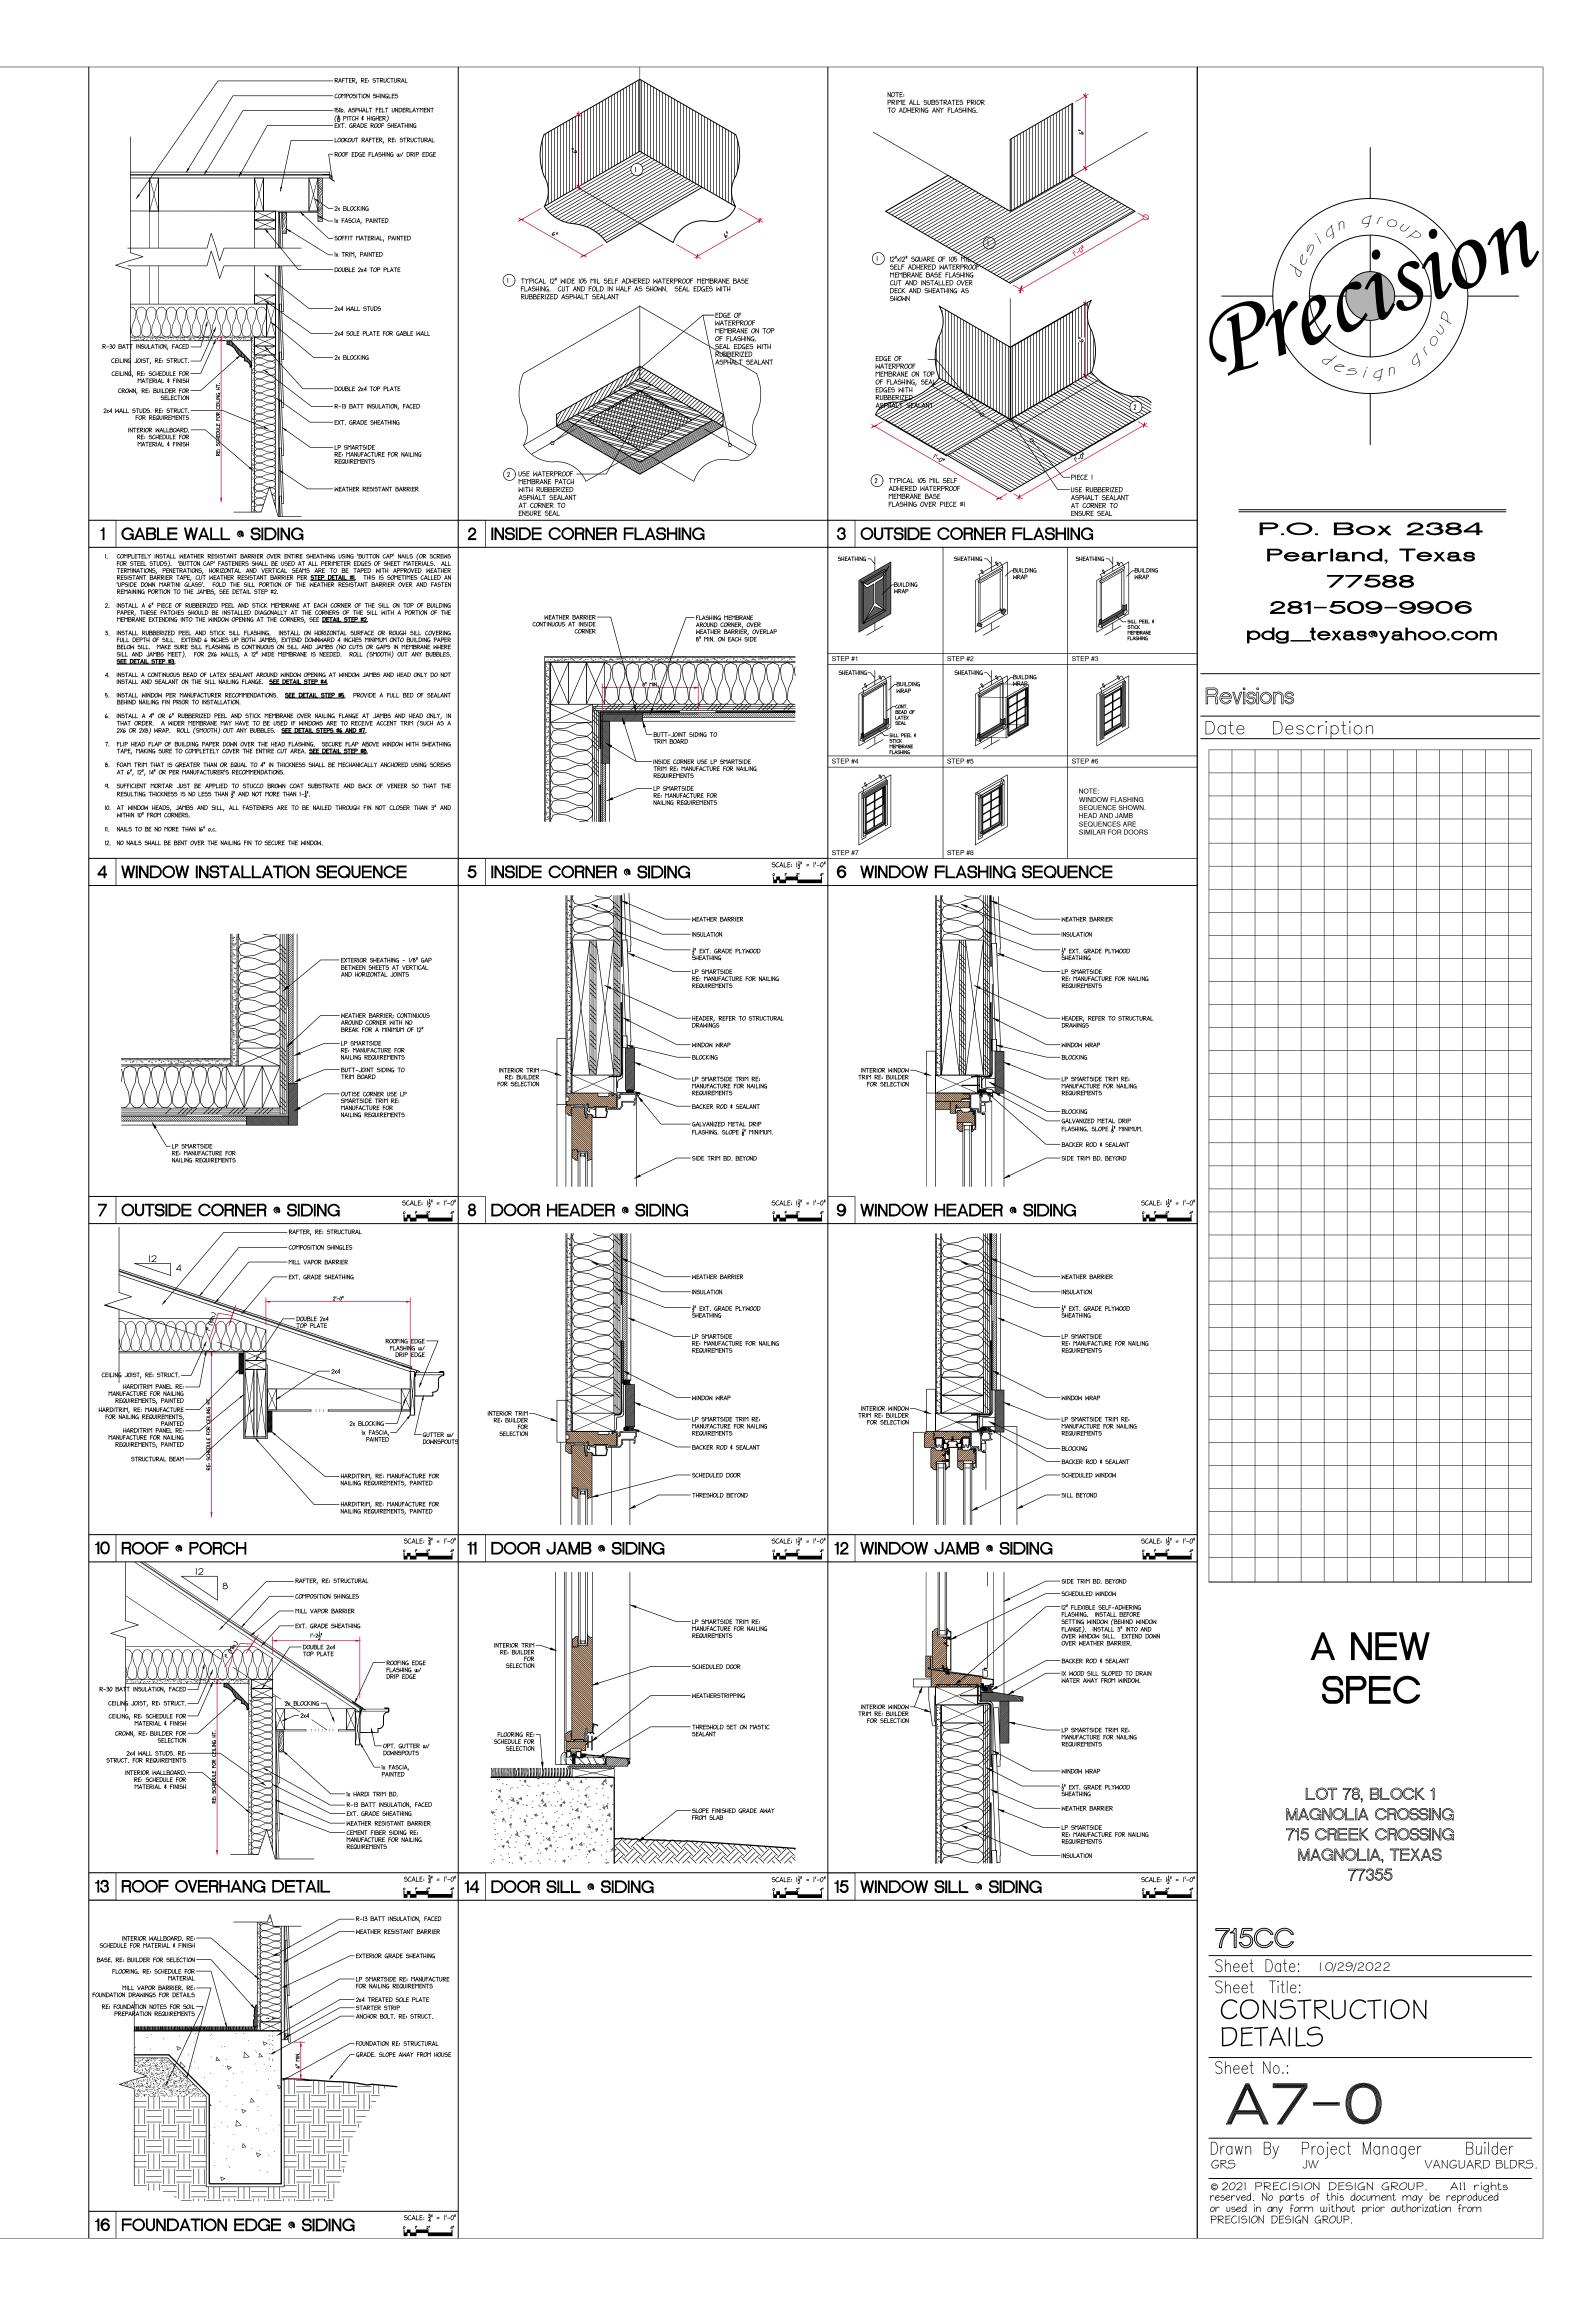


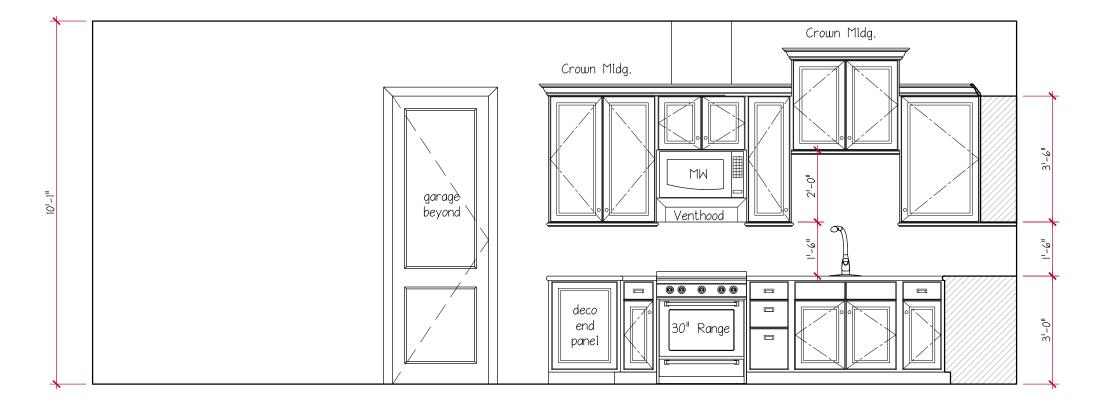


KITCHEN

LIVING	ROOM



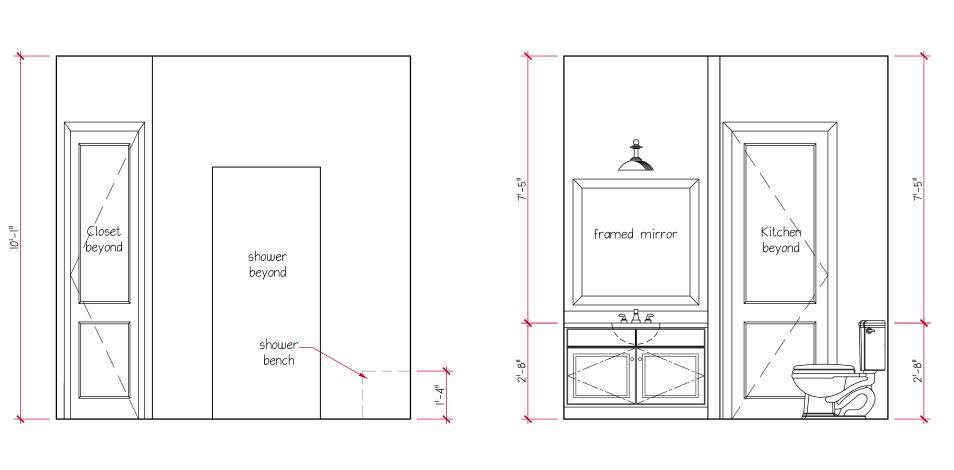

KITCHEN

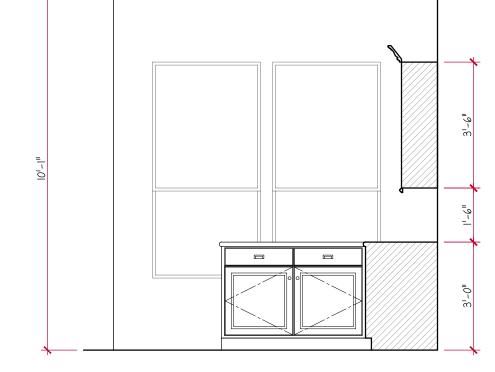



KITCHEN

Drectslon P.O. Box 2384 Pearland, Texas 77588 281-509-9906 pdg_texas@yahoo.com Revisions Date Description A NEW SPEC LOT 78, BLOCK 1 MAGNOLIA CROSSING 715 CREEK CROSSING MAGNOLIA, TEXAS 77355 715CC Sheet Date: 10/29/2022 Sheet Title: INTERIOR ELEVATIONS 3 Sheet No.: **A6-2**

SCALE: 3/8" = 1'-0"

© 2021 PRECISION DESIGN GROUP. All rights reserved. No parts of this document may be reproduced or used in any form without prior authorization from PRECISION DESIGN GROUP.

Drawn By Project Manager Builder GRS JW VANGUARD BLDRS.